



Legend

Building Tour Route Start



Tour Route



Required Buildings



Optional Buildings



 
Gathering Areas



North



Level



**Map 1: Mill Town
Required/ Optional Buildings**

Map 2: Concentration Mill (9 pages)


Map 3: Power Plant

Map 4: Machine Shop

Map 5: West Bunkhouse

Map 6: East Bunkhouse

Map 2: Concentration Mill (9 pages)

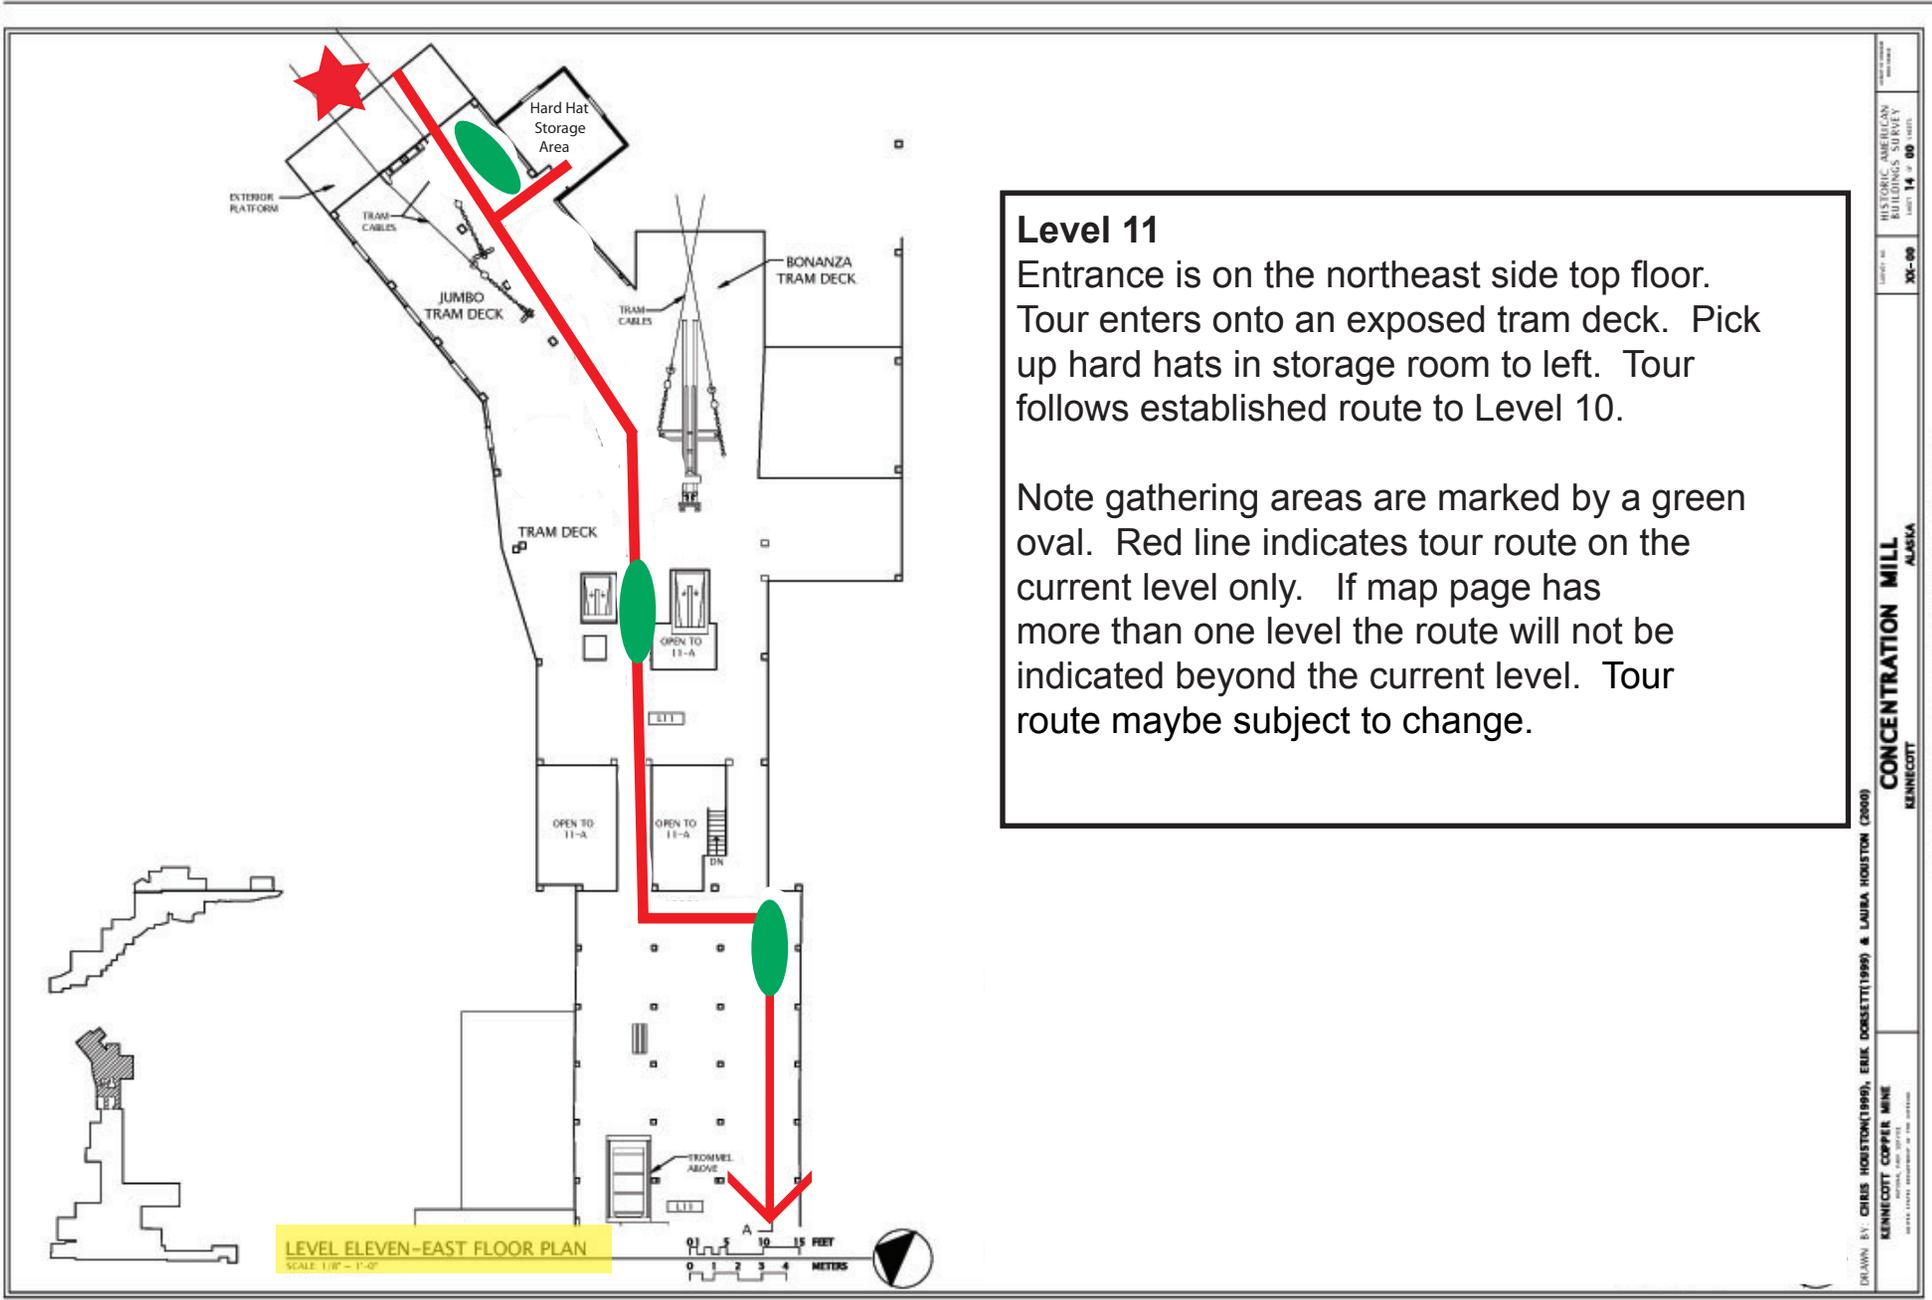


Level 11
Entrance is on the northeast side top floor. Tour enters onto an exposed tram deck. Pick up hard hats in storage room to left. Tour follows established route to Level 10.

Note gathering areas are marked by a green oval. Red line indicates tour route on the current level only. If map page has more than one level the route will not be indicated beyond the current level. Tour route maybe subject to change.

Level 9


Route descends a long perimeter staircase and catwalk to access level 8. No tour gathering spot on level.

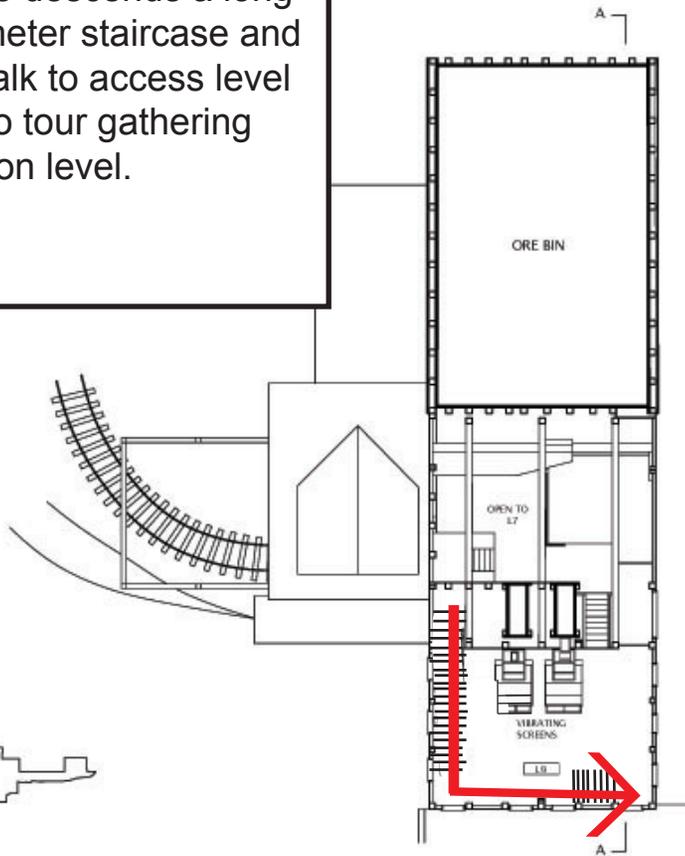

LEVEL NINE FLOOR PLAN
 SCALE 1/8" = 1'-0"

Level 10

Route descends a small staircase to access level. Tour gathers at green oval. Tour follows established route to level 9.

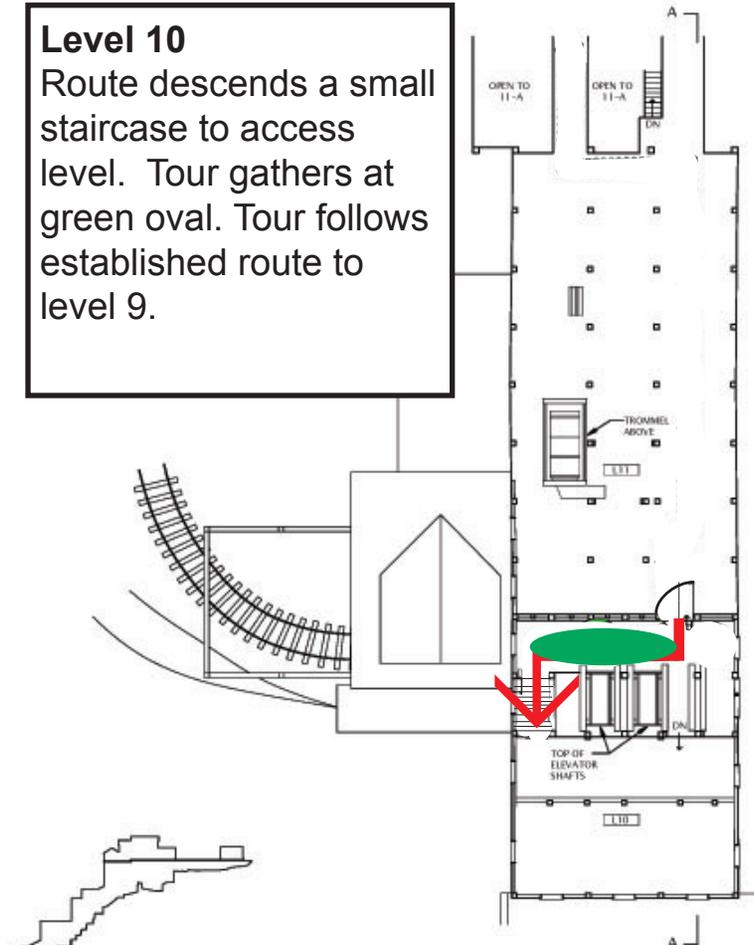


LEVEL TEN AND LEVEL ELEVEN-WEST FLOOR PLAN
 SCALE 1/8" = 1'-0"

Level 7



Has five different elevation areas.
 Tour follows established tour route to level 6. Tour gathering area at green oval.

Level 8


Tour follows established route down the left hand stairwell to level 7. Tour gathering area at green oval.

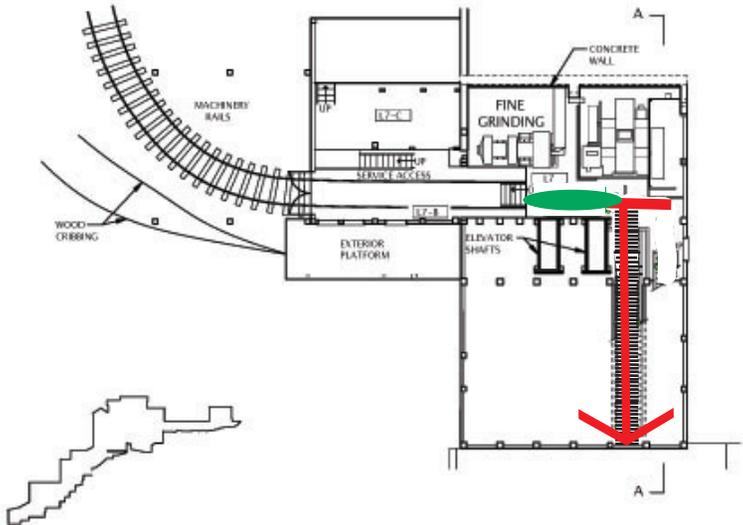


LEVEL SEVEN-
 SCALE 1/8" = 1'-0"

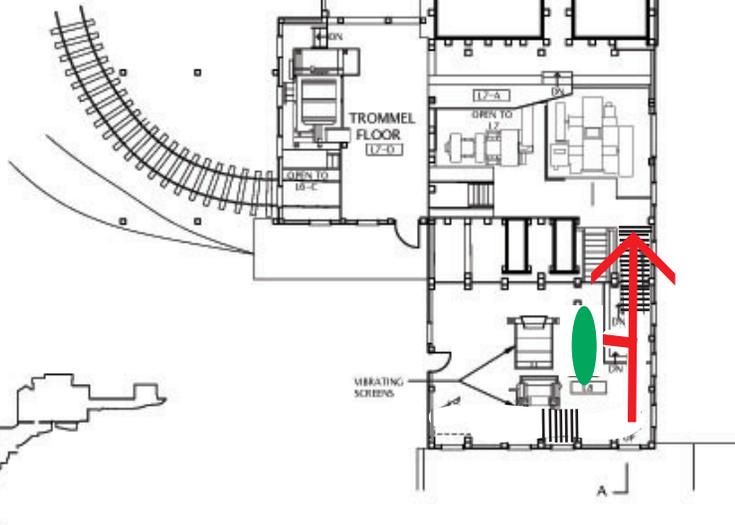 


LEVEL EIGHT FLOOR PLAN

 


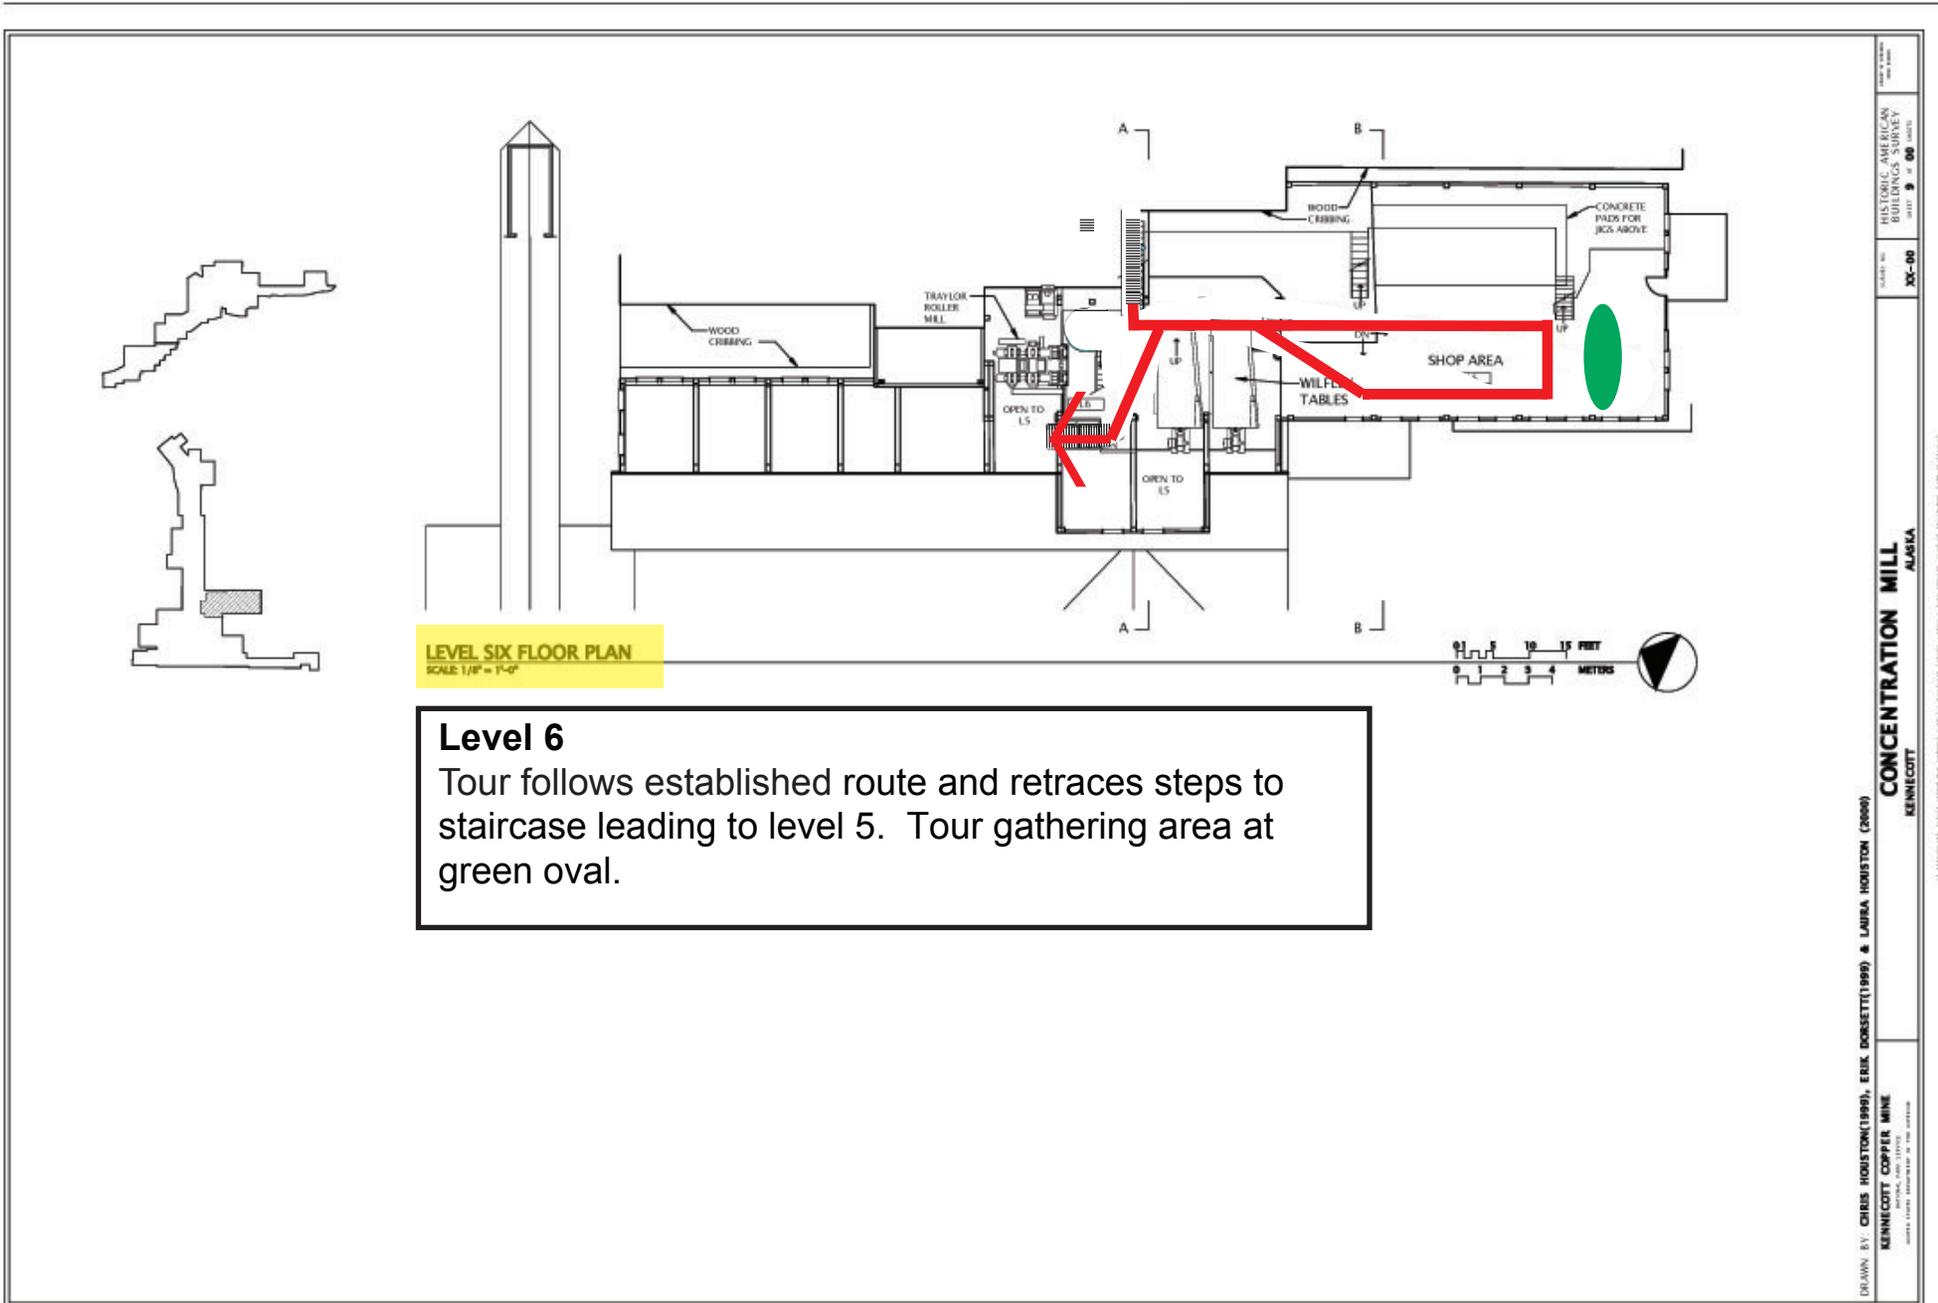


LEVEL SIX FLOOR PLAN
SCALE 1/8" = 1'-0"


Level 6
Tour follows established route and retraces steps to staircase leading to level 5. Tour gathering area at green oval.

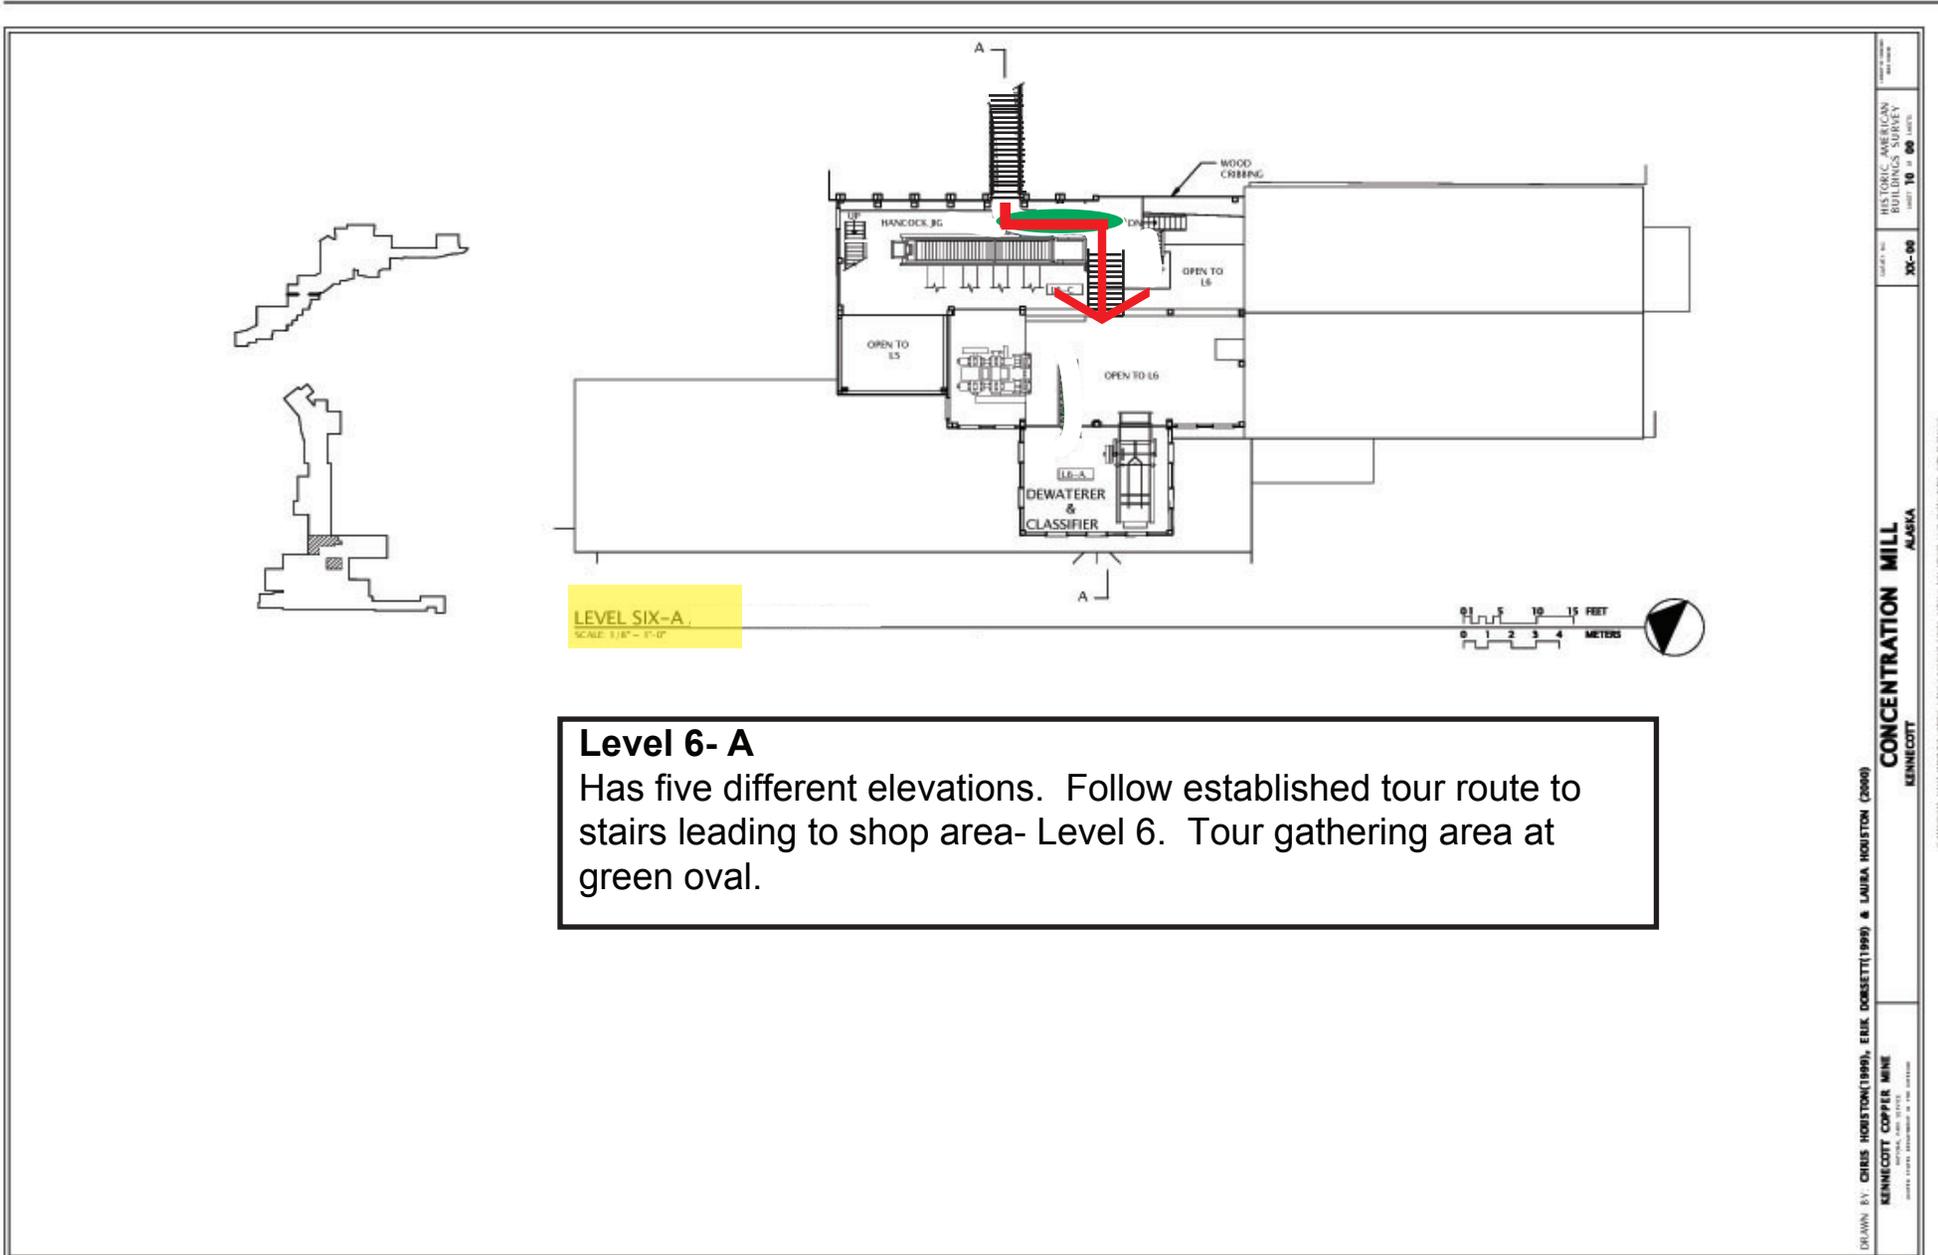



Level 5
Follow established tour route to staircase leading to level 4.
Level has two possible tour gathering areas at green ovals.

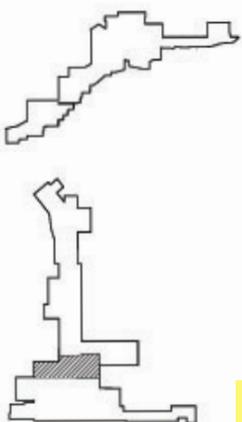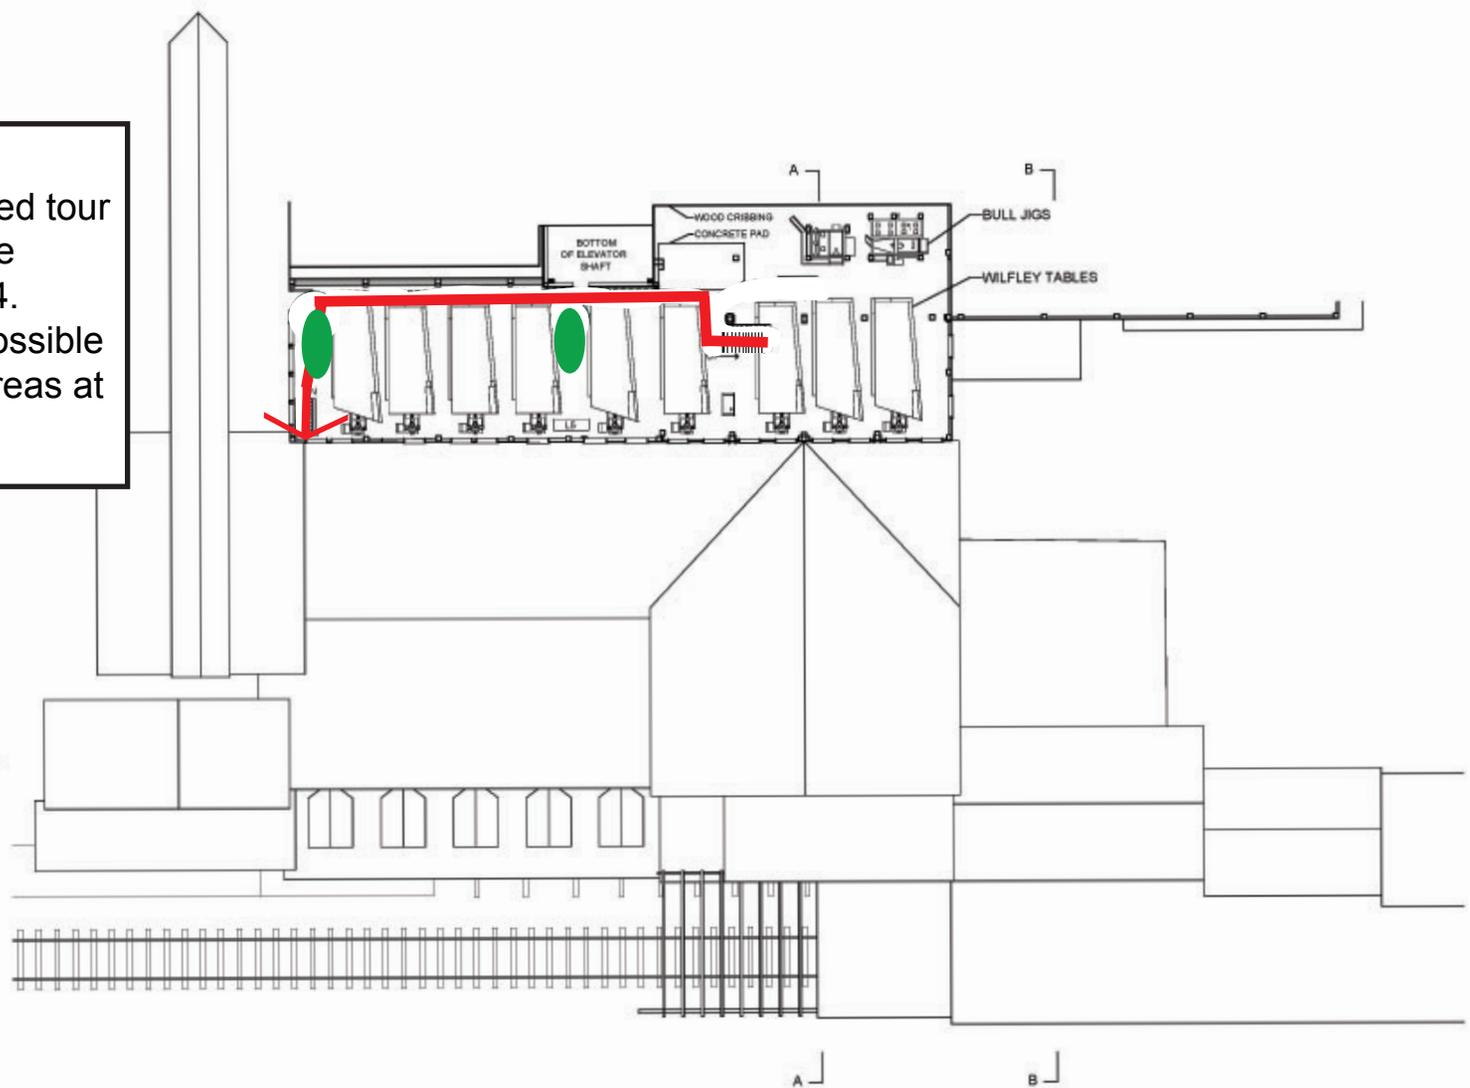

 
LEVEL FIVE FLOOR PLAN
SCALE: 1/8" = 1'-0"




Level 4
Follow established
tour route around
perimeter of room
to level 3 stairwell.
Level has two
possible tour
gathering areas at
green ovals.

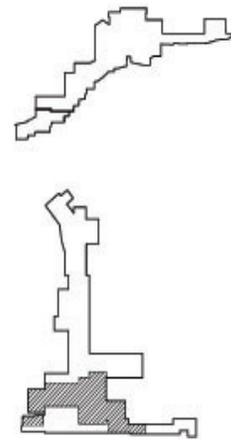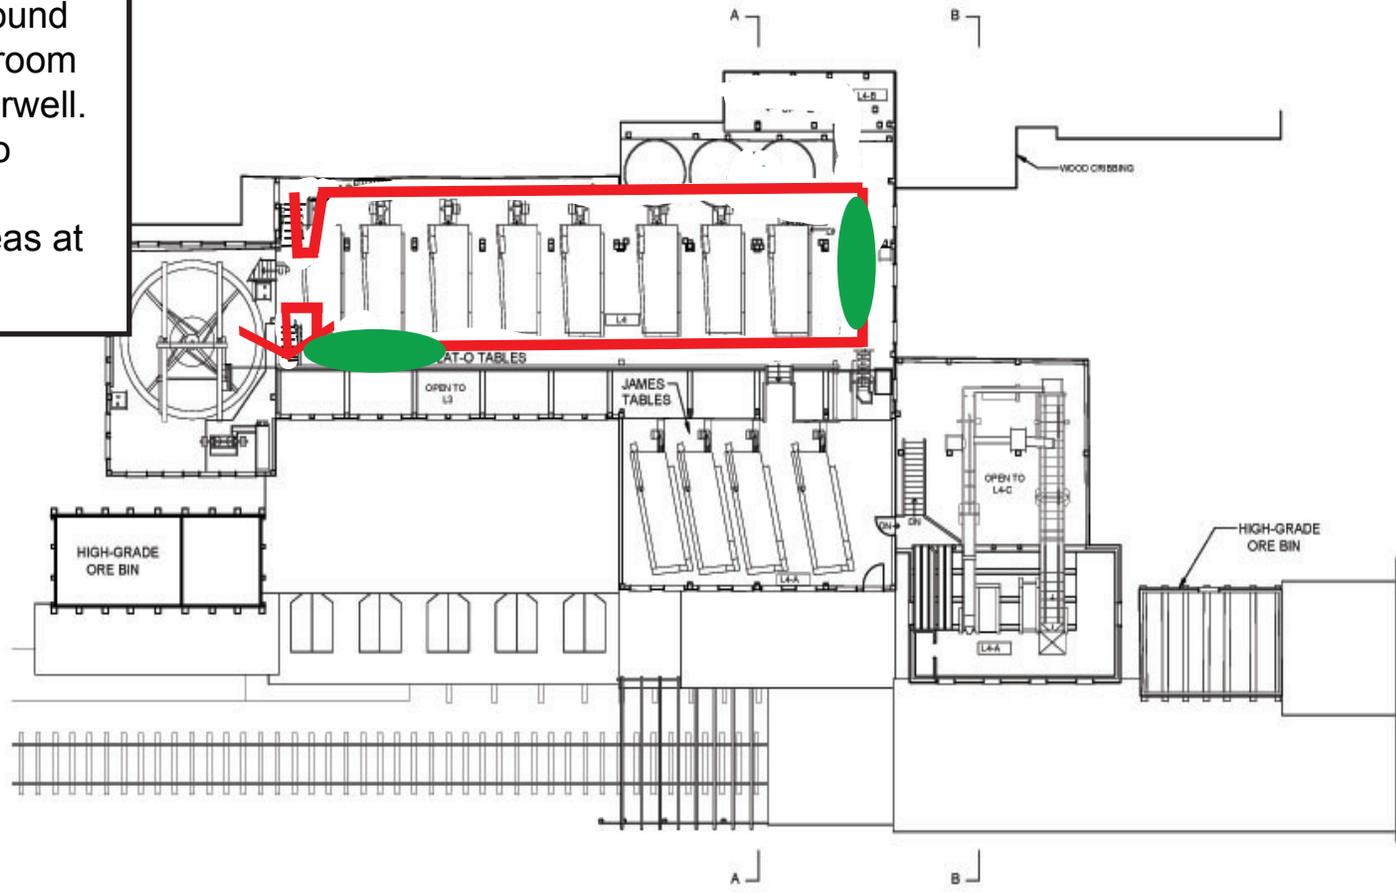

 LEVEL FOUR FLOOR PLAN
SCALE: 1/8" = 1'-0"




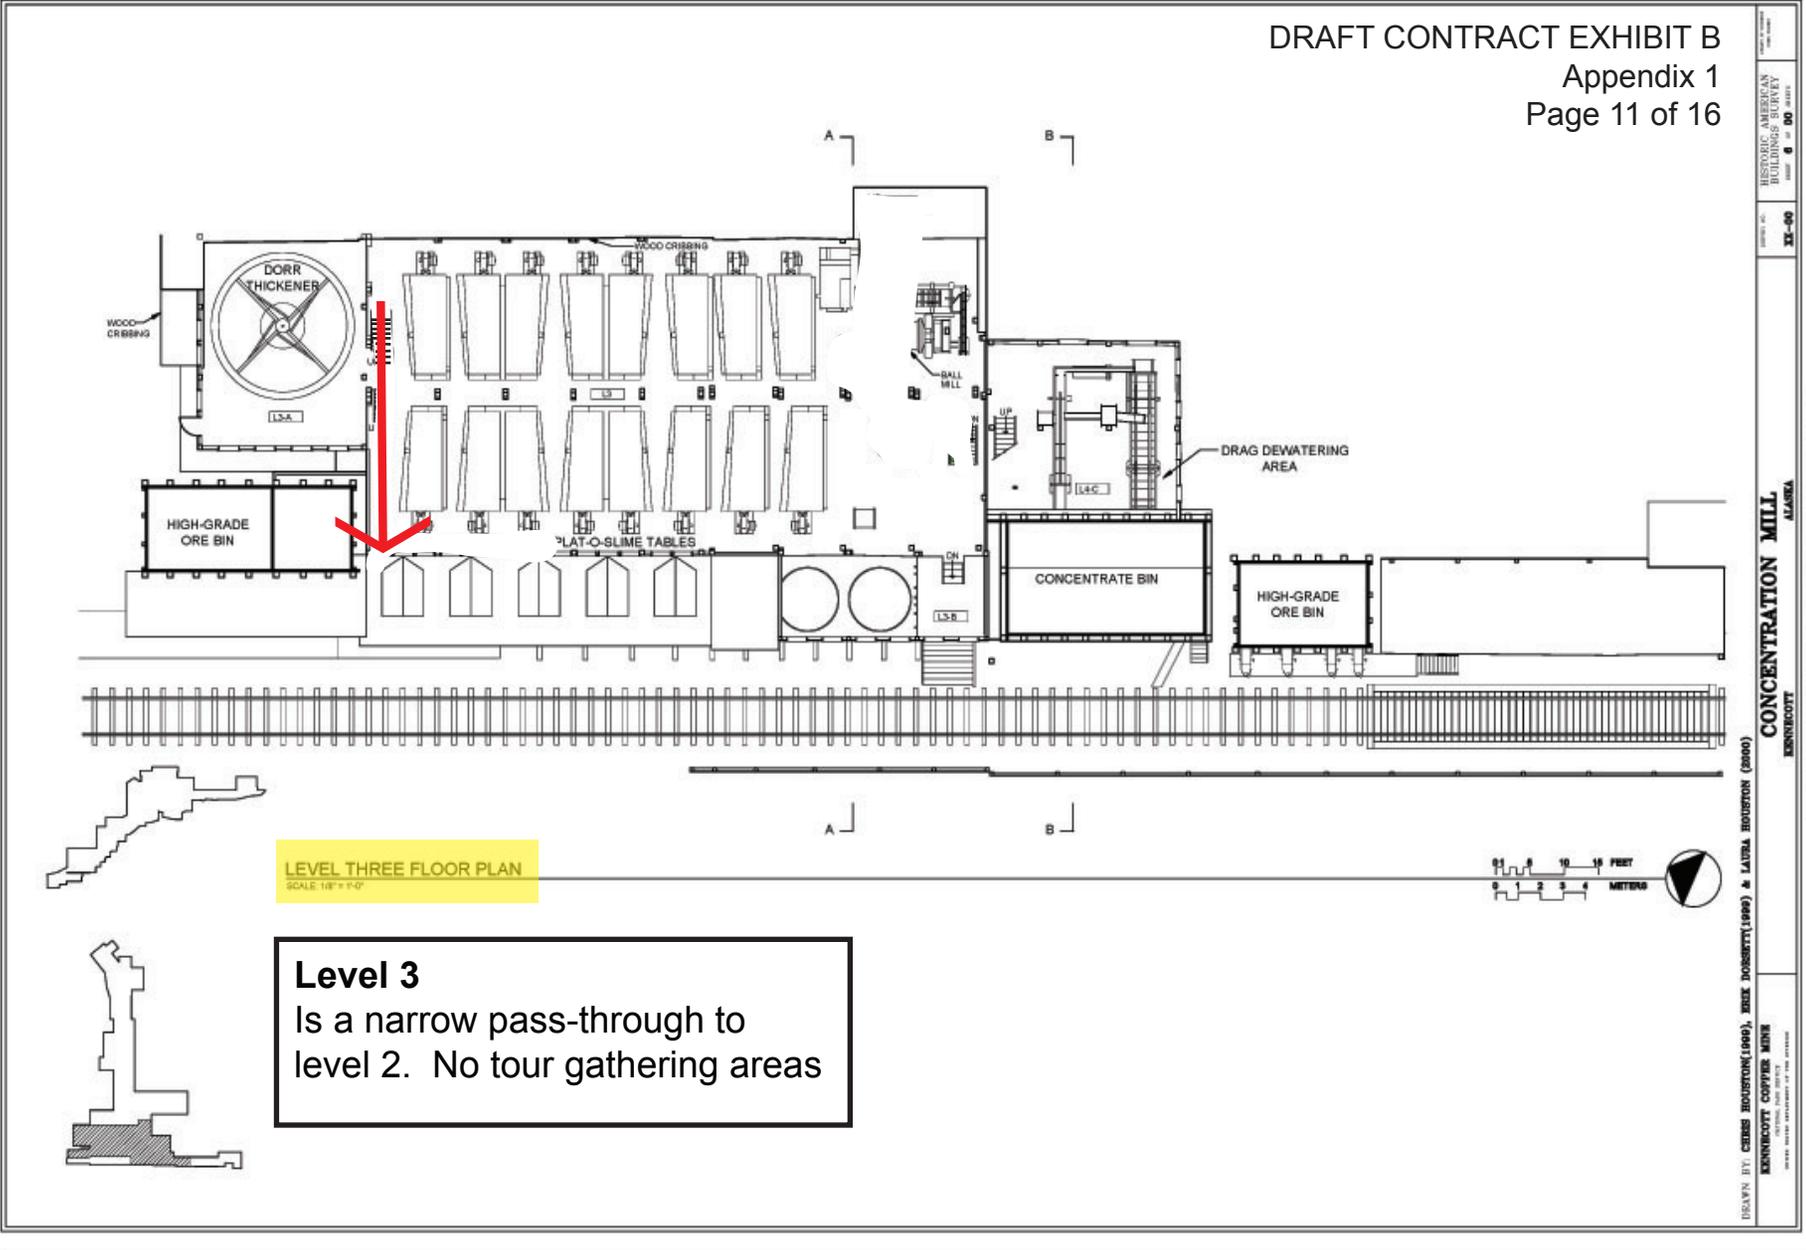

LEVEL THREE FLOOR PLAN
 SCALE: 1/8" = 1'-0"


Level 3
 Is a narrow pass-through to level 2. No tour gathering areas

Level 1
 Follow established route into sacking room. Retrace steps to exit. Tour gathering area at green oval. Hard hats will be stored to the right of room before exit. Follow established route to building exit.

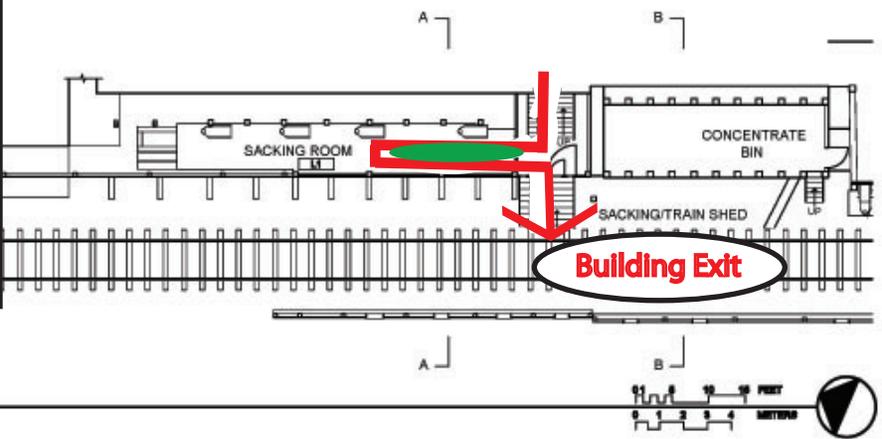


LEVEL ONE-NORTH FLOOR PLAN
SCALE: 1/8" = 1'-0"

Level 2
 Follow established route to staircase leading to level 1. Tour gathering area at green oval.

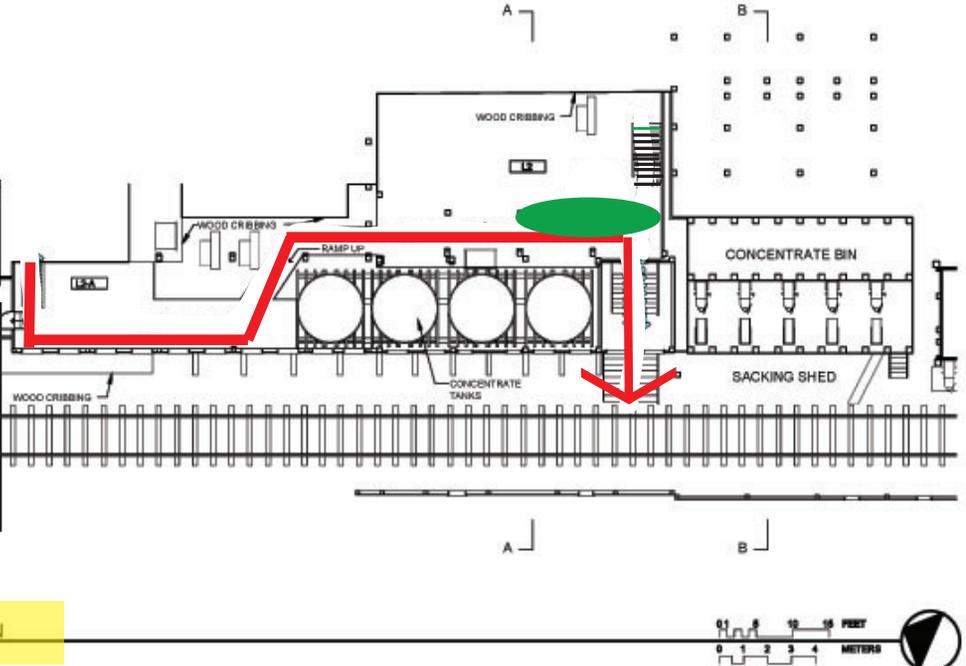

LEVEL TWO-NORTH FLOOR PLAN
SCALE: 1/8" = 1'-0"

Map 3: Power Plant

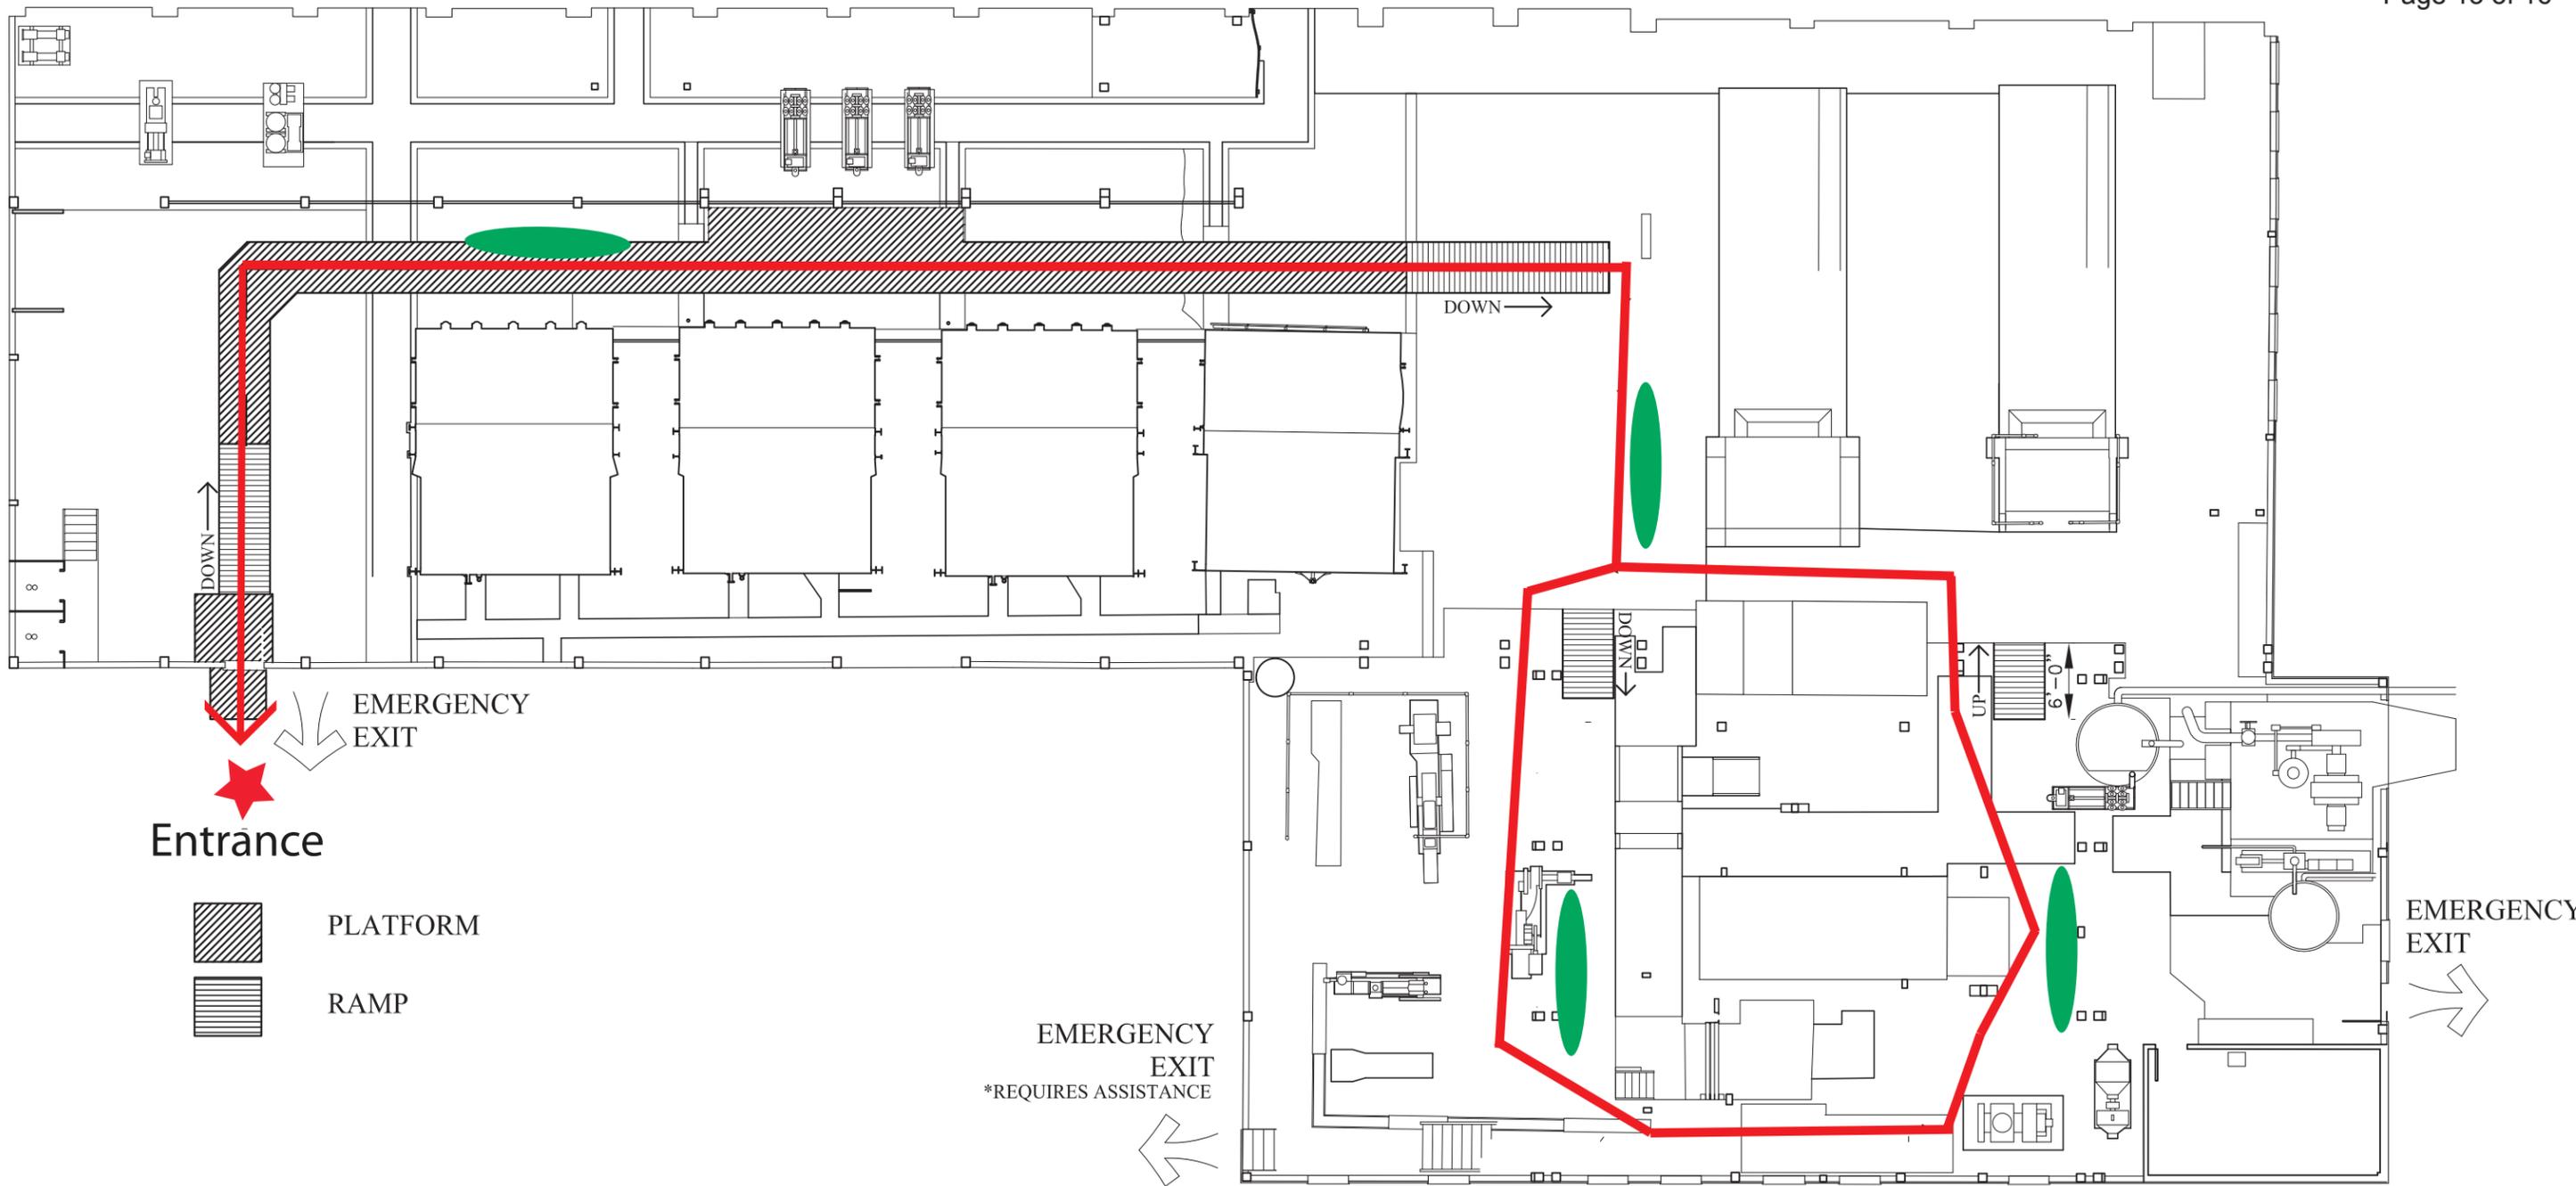


Level 1
Will be entered and exited through the northwest corner entrance (Emergency Exit). Follow established tour route through the building. The group can gather at the green ovals.

Level 2
No entry


1 LEVEL ONE PLAN
1/8"=1'-0"

DESIGNED: ---	SUB SHEET NO. ---	TITLE OF SHEET LEVEL ONE PLAN TOUR ROUTE	DRAWING NO. ---
DRAWN: ---	A1.0	POWER PLANT	PKG. NO. ---
TECH. REVIEW ---		WRANGELL ST. ELIAS NATIONAL PARK & PRESERVE	SHEET ---
DATE: ---			OF ---

Will be entered and exited through the east door (Front Door). Follow the established tour route through the building and retrace your steps to exit the building. The group can gather at the green ovals.

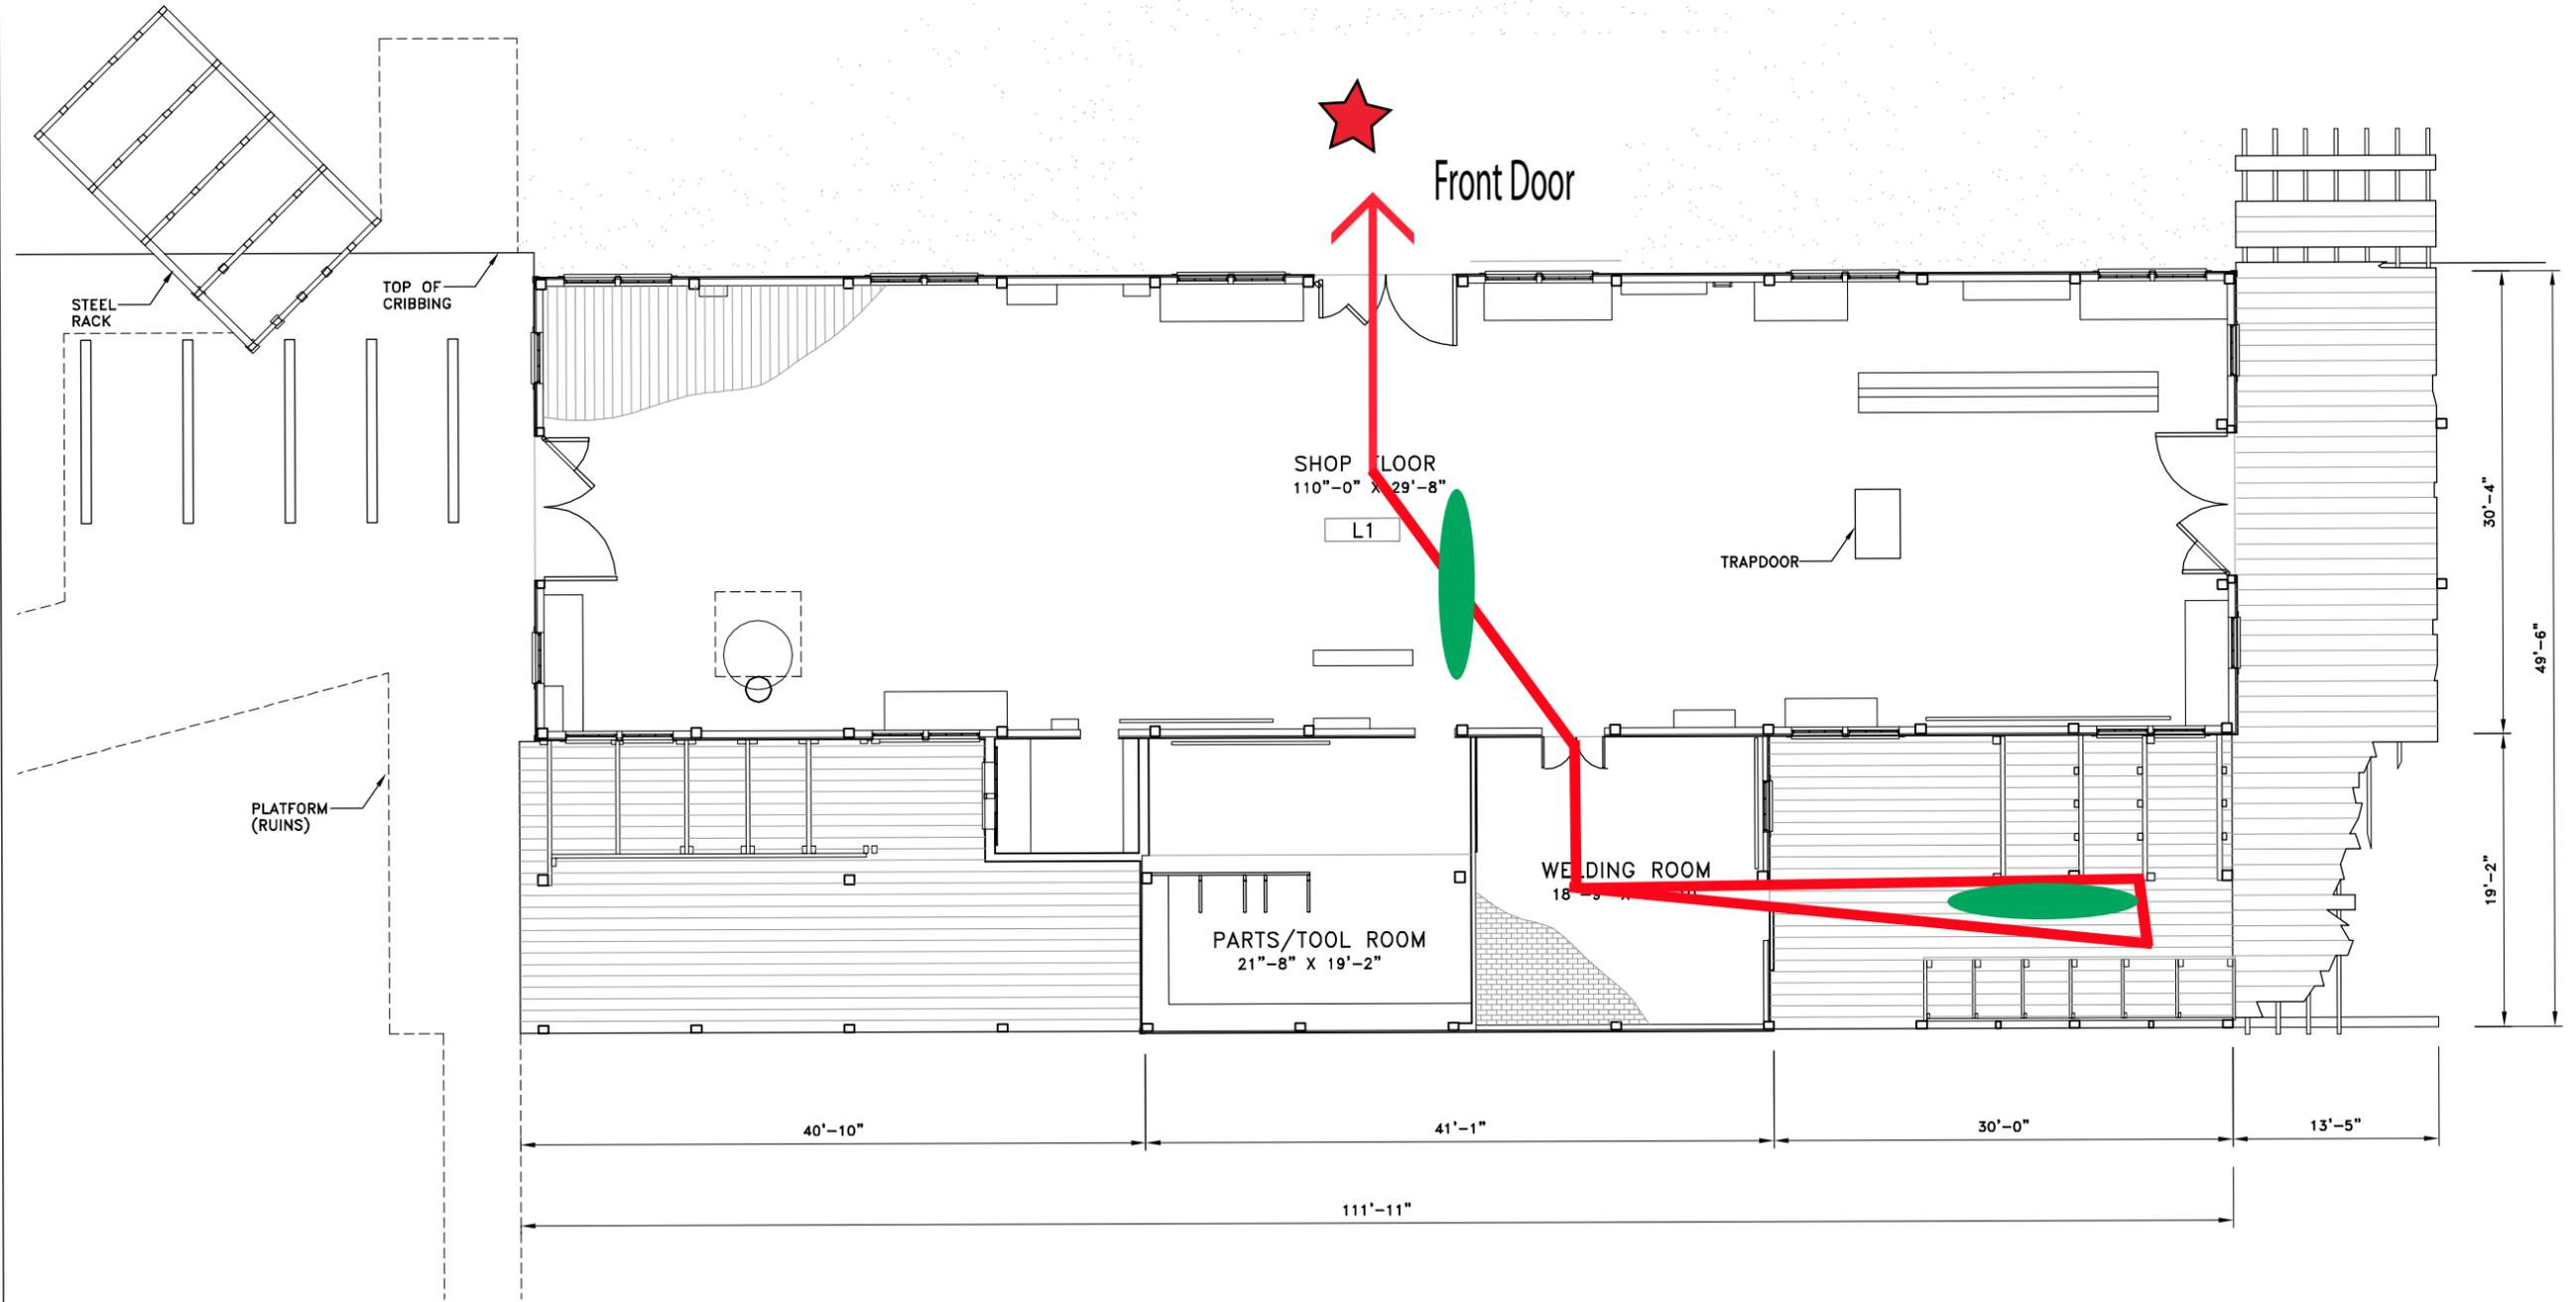

 
LEVEL ONE FLOOR PLAN
SCALE: 3/16" = 1'-0"



DRAWN BY: LAURA HOUSTON(2001) & CHRIS HOUSTON(2001)
 KENNECOTT MINES
 NATIONAL PARK SERVICE
 UNITED STATES DEPARTMENT OF THE INTERIOR
 KENNECOTT
 WRANGELL-ST. ELIAS NATIONAL PARK AND PRESERVE
 ALASKA
 ALASKA
 XX-00
 HISTORIC AMERICAN BUILDINGS SURVEY
 NUMBER 4 OF 9 SHEETS


IF REPRODUCED, PLEASE CREDIT THE HISTORIC AMERICAN BUILDINGS SURVEY, NATIONAL PARK SERVICE, NAME OF INDIVIDUAL, NAME OF ORGANIZATION, DATE OF DRAWING

Map 5: West Bunkhouse

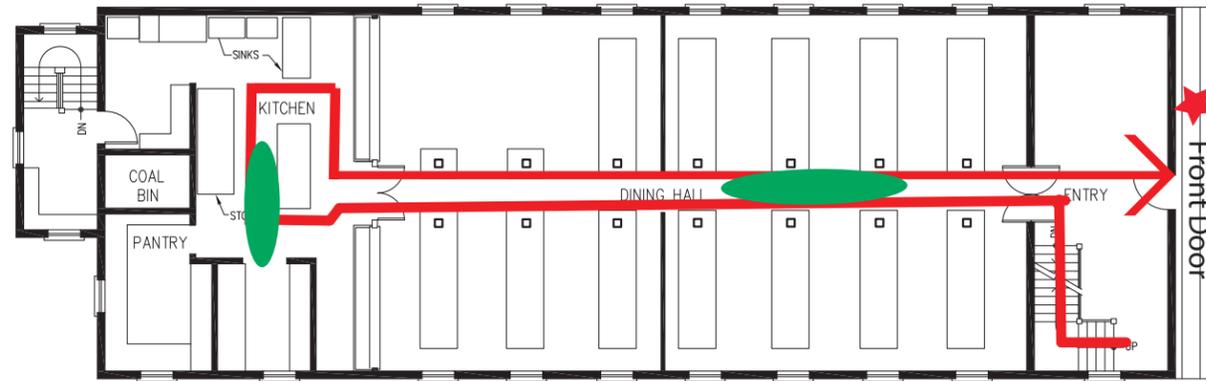


FIRST FLOOR PLAN

SCALE: 1/8" = 1'-0"

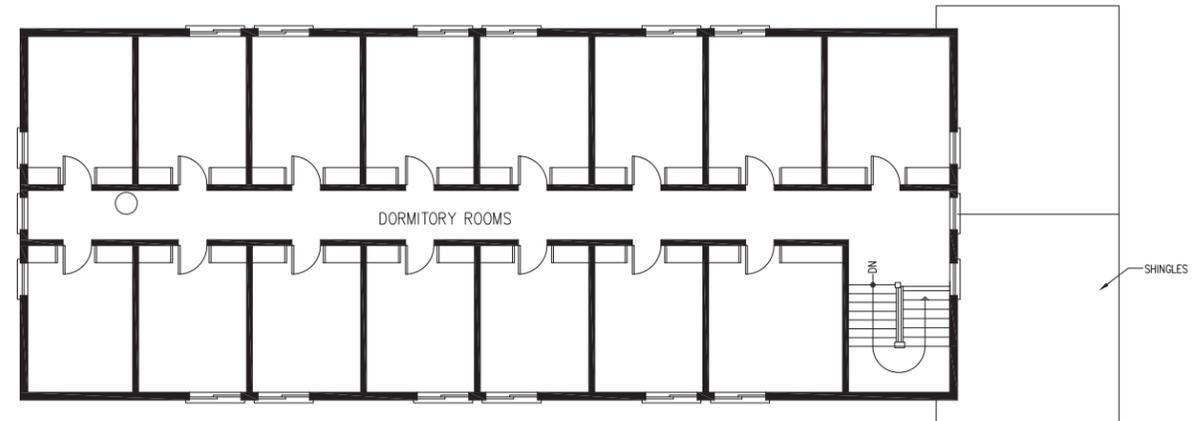


THIRD FLOOR PLAN

SCALE: 1/8" = 1'-0"

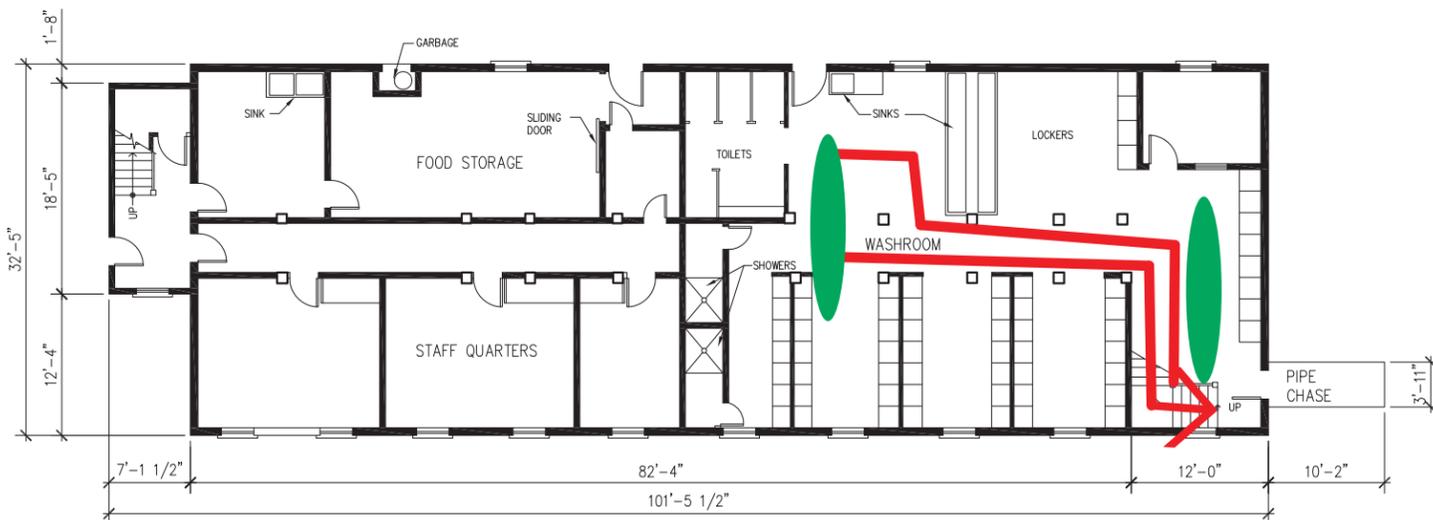

GROUND FLOOR PLAN

SCALE: 1/8" = 1'-0"

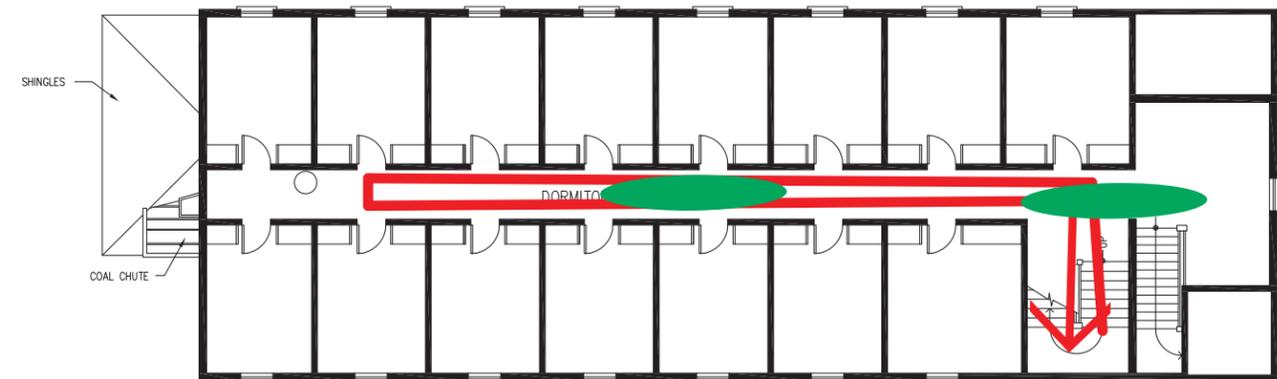

SECOND FLOOR PLAN

SCALE: 1/8" = 1'-0"

Is entered through the east door (Front Door) facing the main street level. The bunkhouse has four levels authorized for access. Follow established tour route and retrace your steps to exit each level. The group can gather at green ovals.


DESIGNED: ..	SUB SHEET NO. XX	TITLE OF SHEET FLOOR PLAN	DRAWING NO. 1XX 80,XXX
DRAWN: LLH		WEST BUNKHOUSE KENNECOTT MINES N.H.L.	PKG. NO. 01
TECH. REVIEW		WRANGELL-ST. ELIAS NATIONAL PARK & PRESERVE	SHEET OF 02
DATE: 6/8/01			

Map 6: East Bunkhouse

Level 1



Entrance is on the west end of building. Follow established tour route to stairwell. Tour group can gather at green oval.

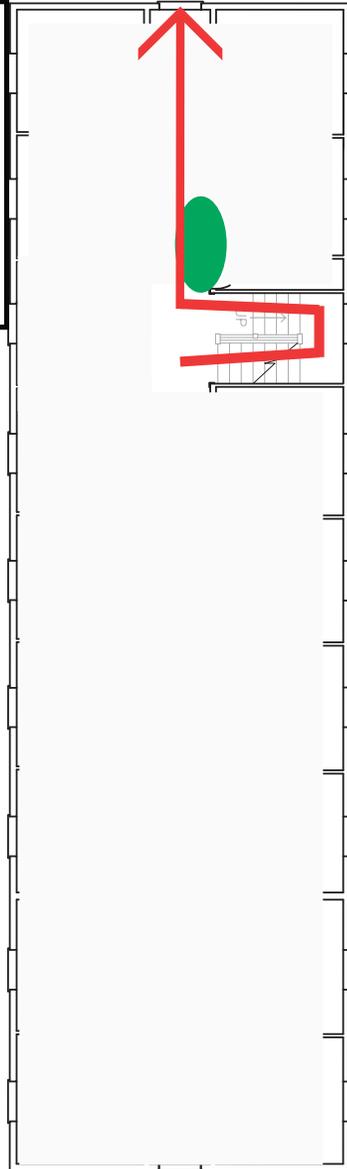

Level 2

Tour can explore the rooms on the second level and retrace your steps to exit. Tour group can gather at green oval.

